

## 5TH STREET AND BEVIER PLACE SEWER SEPARATION AND AVON STREET WATER MAIN REPLACEMENT

AUGUST 2023 GENERALLY LOCATED IN THE N. 1/2 OF SEC. 27, T38N, R8E

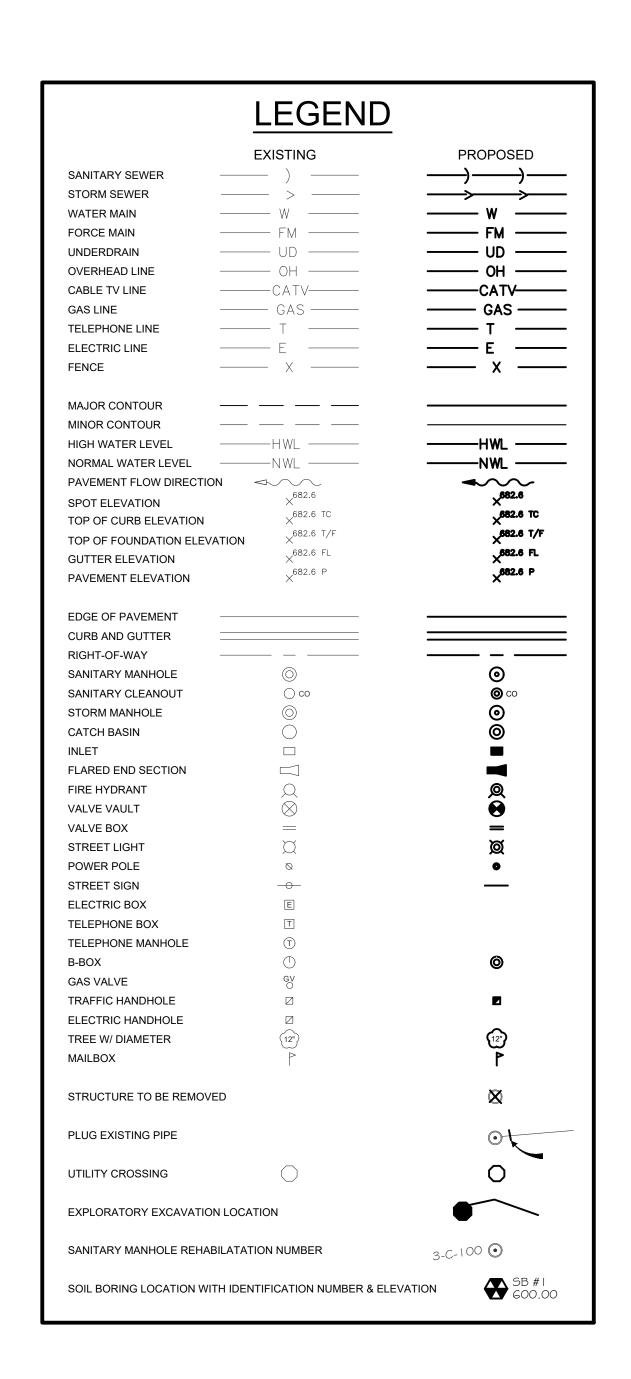

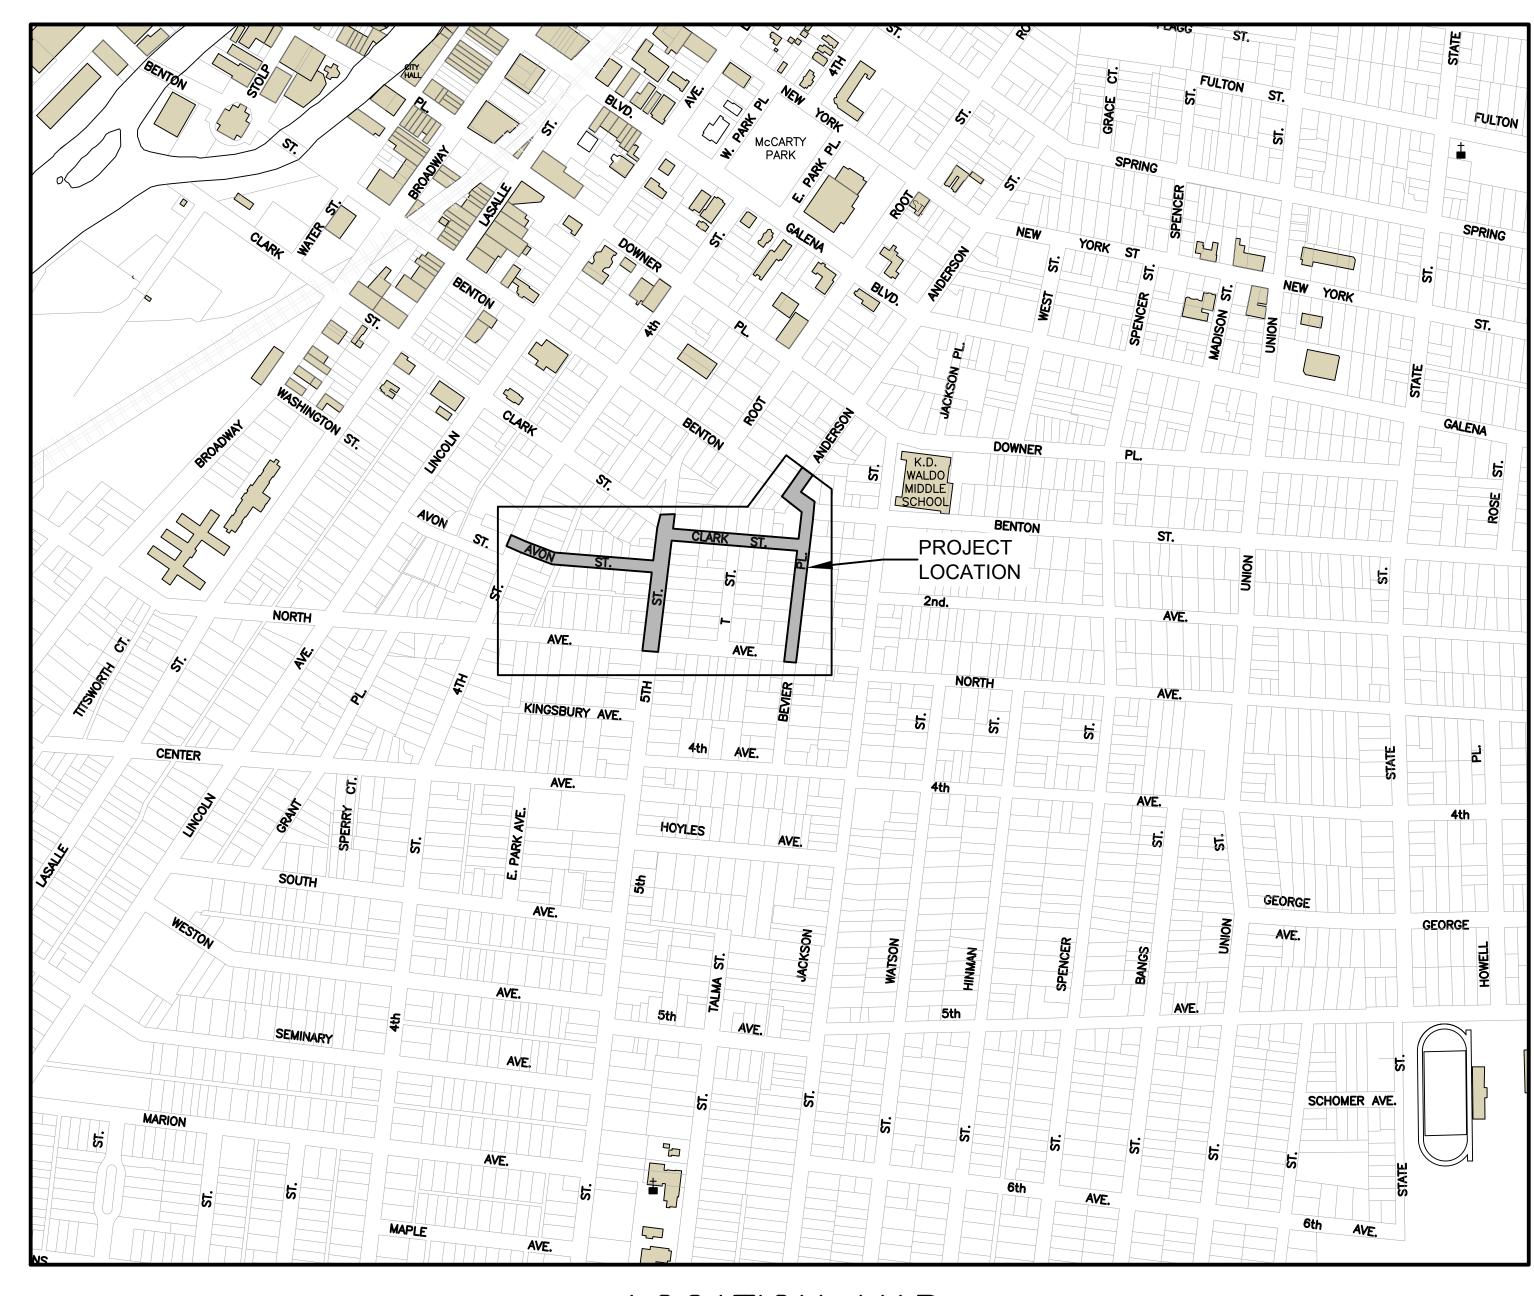

## INDEX OF SHEETS

1 COVER SHEET

2 - 9 PLAN AND PROFILE

10 - 15 STANDARD DETAILS

LOCATION MAP

PLANS PREPARED BY:

## CITY OF AURORA

DEPARTMENT OF PUBLIC WORKS - ENGINEERING DIVISION 77 S. BROADWAY AVE, AURORA, IL 60505

PHONE: 630-256-3200 FAX: 630-256-3229

REVISIONS:					
				HORIZ. SCALE: N/A	
DESIGNED BY: NS	DRAWN BY: MH	CHECKED BY: KTM	APPROVED BY: KTM	VERT. SCALE: N/A	DATE: AUG. 2023

STAMP		DATE
ILLINOIS REGISTERED PROFE	SSIONAL	
ENGINEER No.	062-070660	
LICENSE EXPIRES	NOVEMBER 30, 2023	