

## FOX VALLEY CENTER DRIVE WATER MAIN REPLACEMENT

AUGUST, 2018 GENERALLY LOCATED: SE 1/4 SECTION 21, T38N, R9E, NAPERVILLE TOWNSHIP

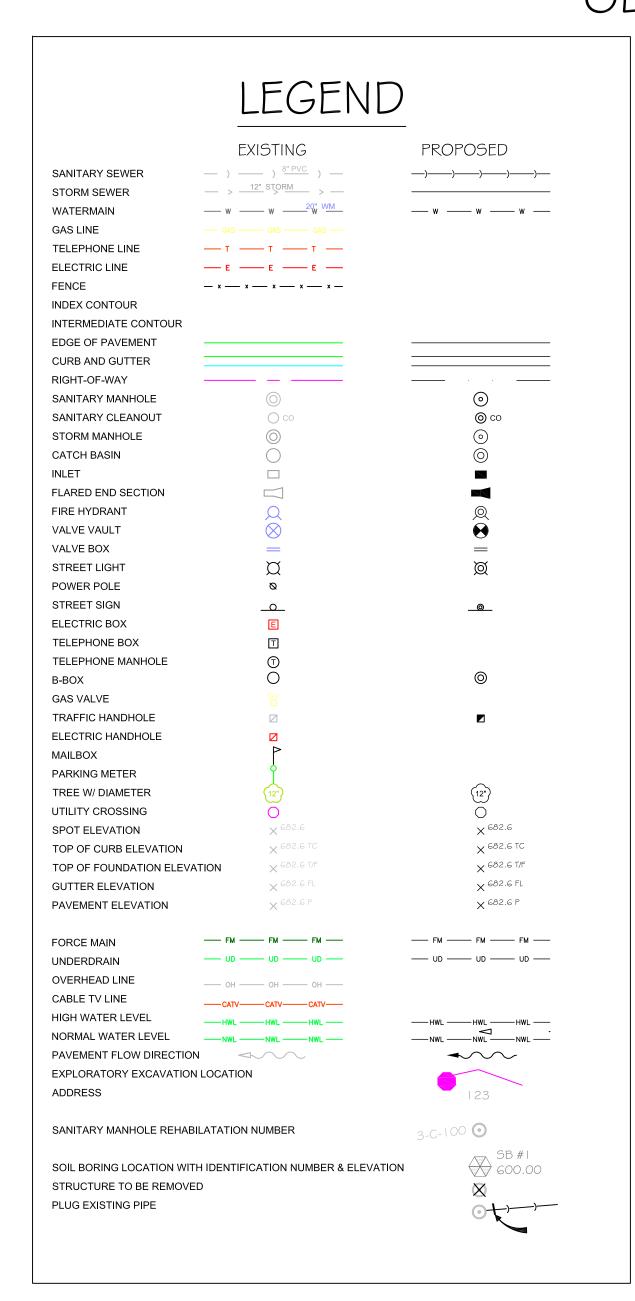

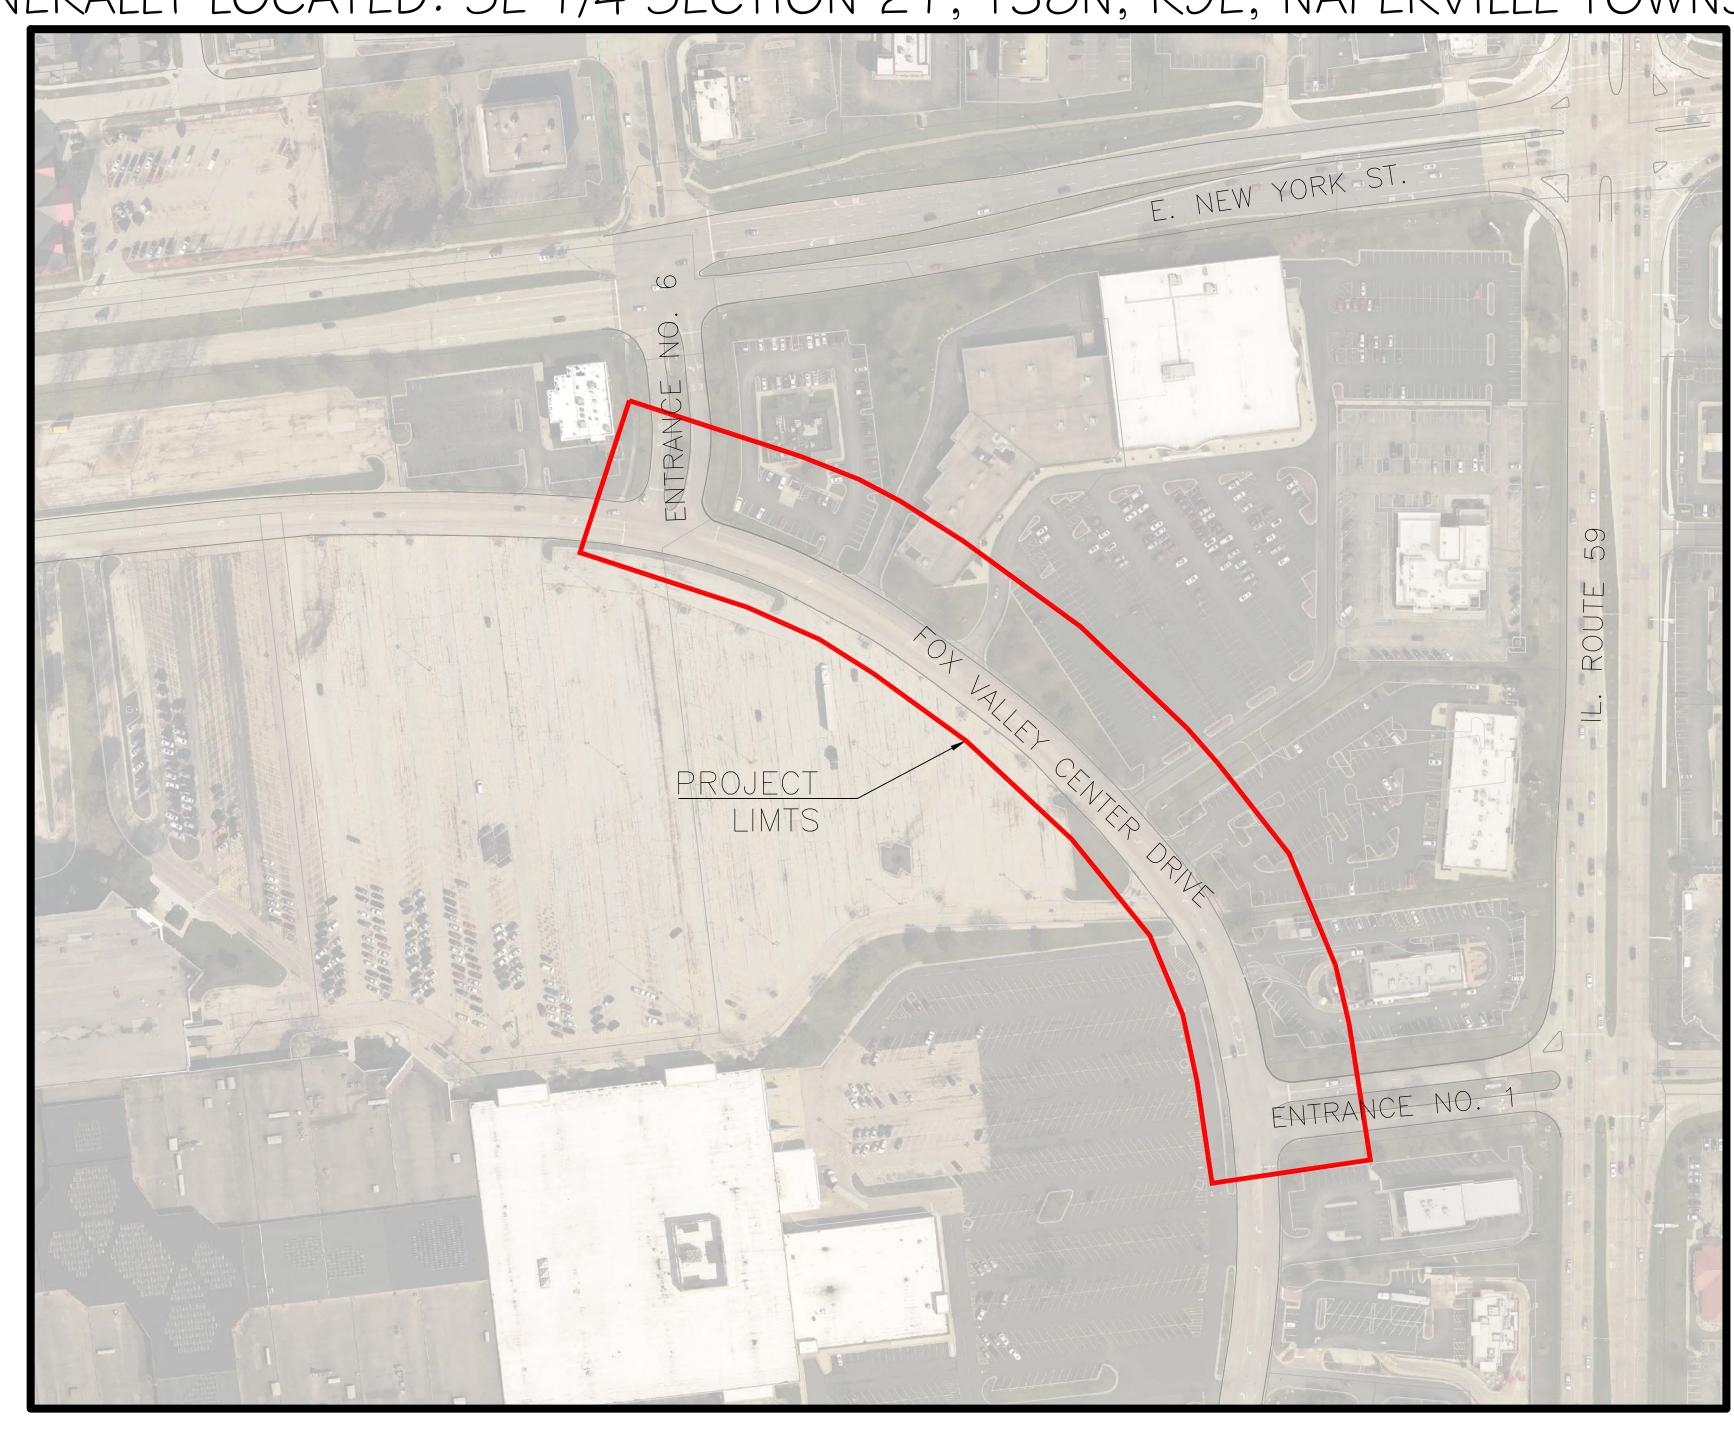

## INDEX OF SHEETS

- 1 COVER SHEET
- 2-5 PLAN AND PROFILE
- 6-9 STANDARD DETAIL SHEETS

PLANS PREPARED BY:

## CITY OF AURORA

DEPARTMENT OF PUBLIC WORKS, DIVISION OF ENGINEERING
44 E. DOWNER PLACE - AURORA, IL

PHONE: 630-256-3200 FAX: 630-256-3229

REVISIONS:							
	_						
						HORIZ. SCALE: N/A	
ESIGNED BY: KTM	DRAWN BY:	AH	CHECKED BY:	JMB	APPROVED BY: JMB	VERT. SCALE: N/A	DATE: AUG 2018
	<u>'</u>		<u> </u>		1	'	1

STAMP		DATE
ILLINOIS REGISTERED PROFES:	SIONAL	
ENGINEER No.	062-59993	
LICENSE EXPIRES	NOVEMBER 30, 2017	