



HYDRANT COVERAGE MAP
SCALE: 1"=200'

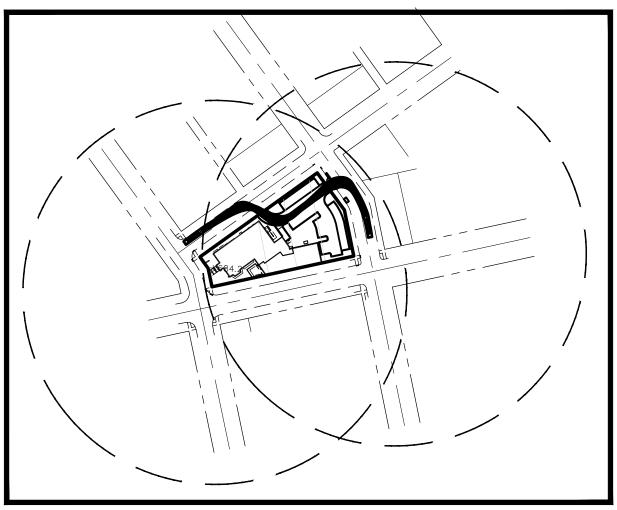

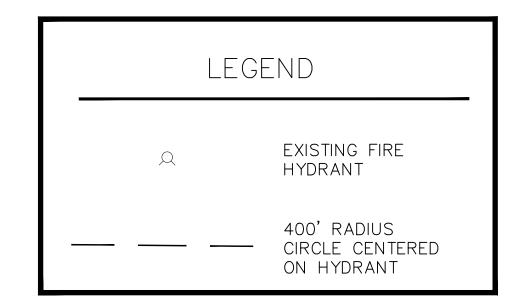

OWNER/DEVELOPER: FOX VALLEY APARTMENTS, LP 346 N LAKE STREET AURORA, IL 60506

Fire Access Plan Data Table (Todd Adaptive Reuse)		
<u>Description</u>	<u>Value</u>	<u>Unit</u>
a) Building Height	37.00	feet
b) Building Square Footage (typical)	24,293	square feet

c) Building fire suppression information including any proposed use of sprinkler systems, fire alarm systems, whether fire extinguishers are needed:

Building will be fully sprinklered per NFPA 13R. Fire alram system will be provided in the corridors and common areas with unit smoke detection system in each unit. Fire extingushers will be provided in common areas.

d) General description of business to be conducted within each building including: will there be rack storage in the building, will there be storage of combustible materials over twelve feet in height, clearance of sprinkler heads and stored materials (18 inch minimum):

Building will be primariliy used for multi-family residential units with accessory space alloted for the use of social service facility, separated from the primary structure with 2 hour fire seperation.

One Overlook Point, Suite 290, Lincolnshire, IL 60069 ph:847.634.5550 fx:847.634.0095 menherd.cor Givil Engineers • Surveyors • Water Resource Engineers • Water & Wastewater Engineer Construction Managers • Environmental Scientists • Landscape Architects • Planner

TODD SCHOOL ADAPTIVE REUSE
CITY OF AURORA, ILLINOIS
FIRE ACCESS PLAN FOR XXXXX

PROJ. MGR.: <u>TEC</u>
PROJ. ASSOC.: <u>STG</u>
DRAWN BY: <u>GTB</u>
DATE: <u>08-04-202</u>
SCALE: <u>1" = 20'</u>

SHEET

CCAUILO3