

WEST NEW YORK ST. & SPRUCE ST. SEWER SEPARATION, HIGHLAND AVE. TO BLACKHAWK ST. JANUARY 2017 GENERALLY LOCATED: T38N, R8E, SECTION 21, AURORA TOWNSHIP

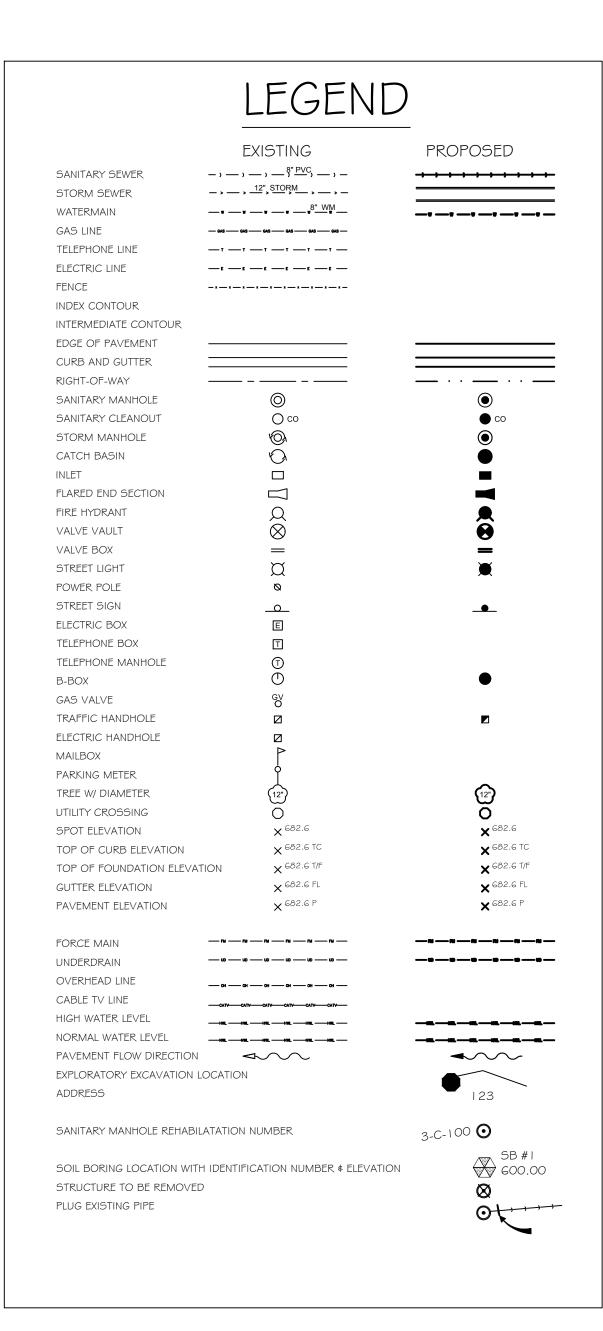

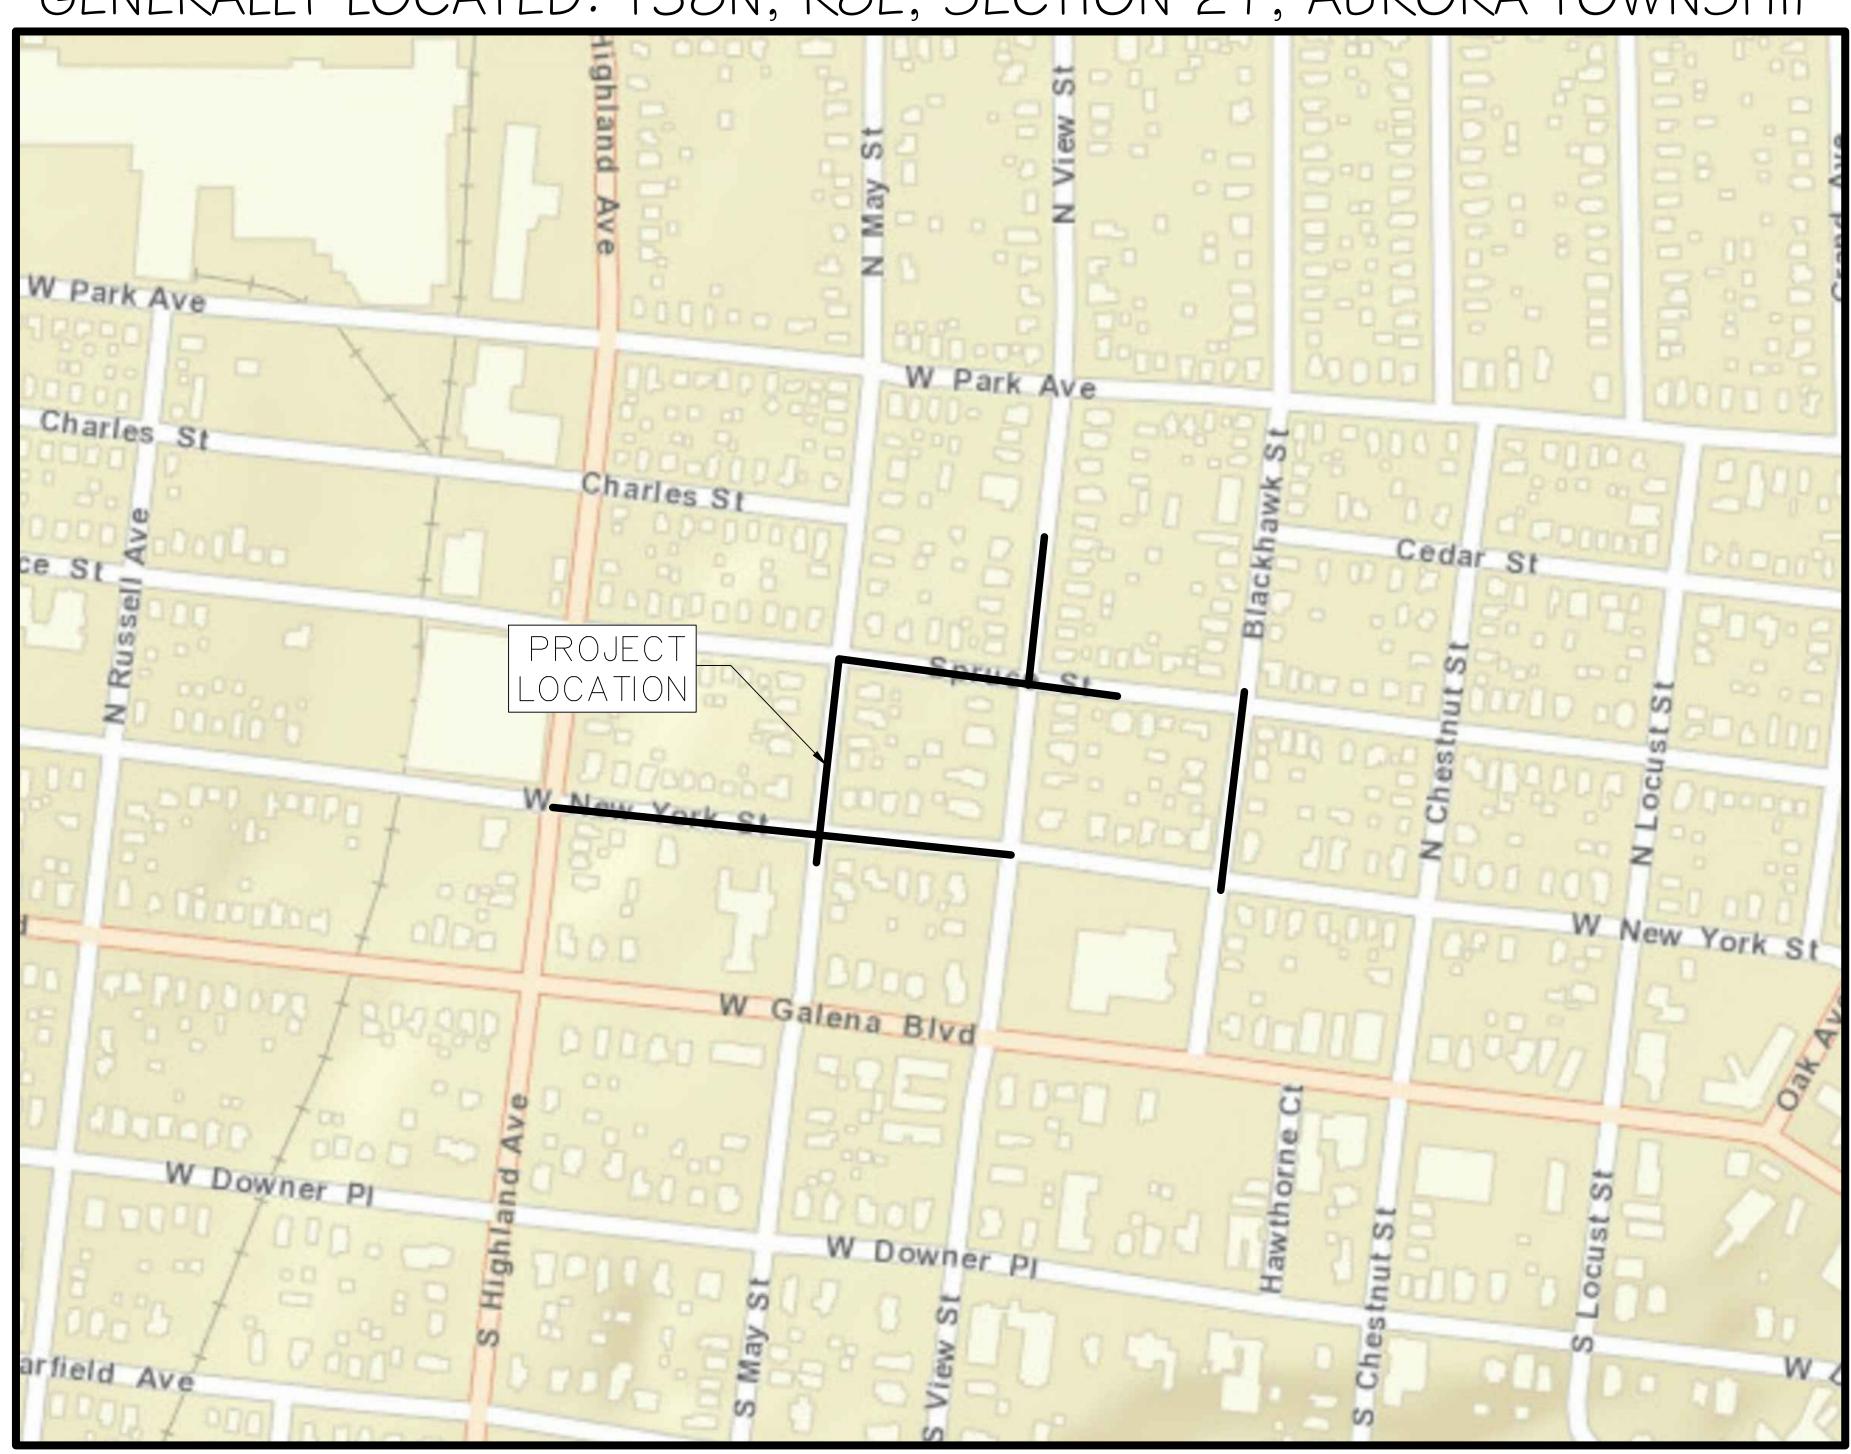



PER CITY OF AURORA - 2/13/17

					HORIZ. SCALE: N/A	
о вү: КТМ	DRAWN BY:	EAM	CHECKED BY: KTM	APPROVED BY: KTM	VERT. SCALE: N/A	DATE: 1/2017

INDEX OF SHEETS

1	COVER SHEET
2	OVERALL SITE PLAN
3-8	PLAN AND PROFILES
9-11	STANDARD DETAILS

PLANS PERPARED BY:



WBK ENGINEERING, LLC 116 WEST MAIN STREET, SUITE 201, ST. CHARLES, ILLINOIS 60174 P: 630.443.7755 F: 630.443.0533 WWW.WBKENGINEERING.COM PROFESSIONAL DESIGN FIRM NO. 184.007317

EXPIRATION DATE: 04/30/2017

ILLINOIS REGISTERED PROFESSIONAL

ENGINEER No.

LICENSE EXPIRES

NOVERMBER 30, 2017

062-059933